


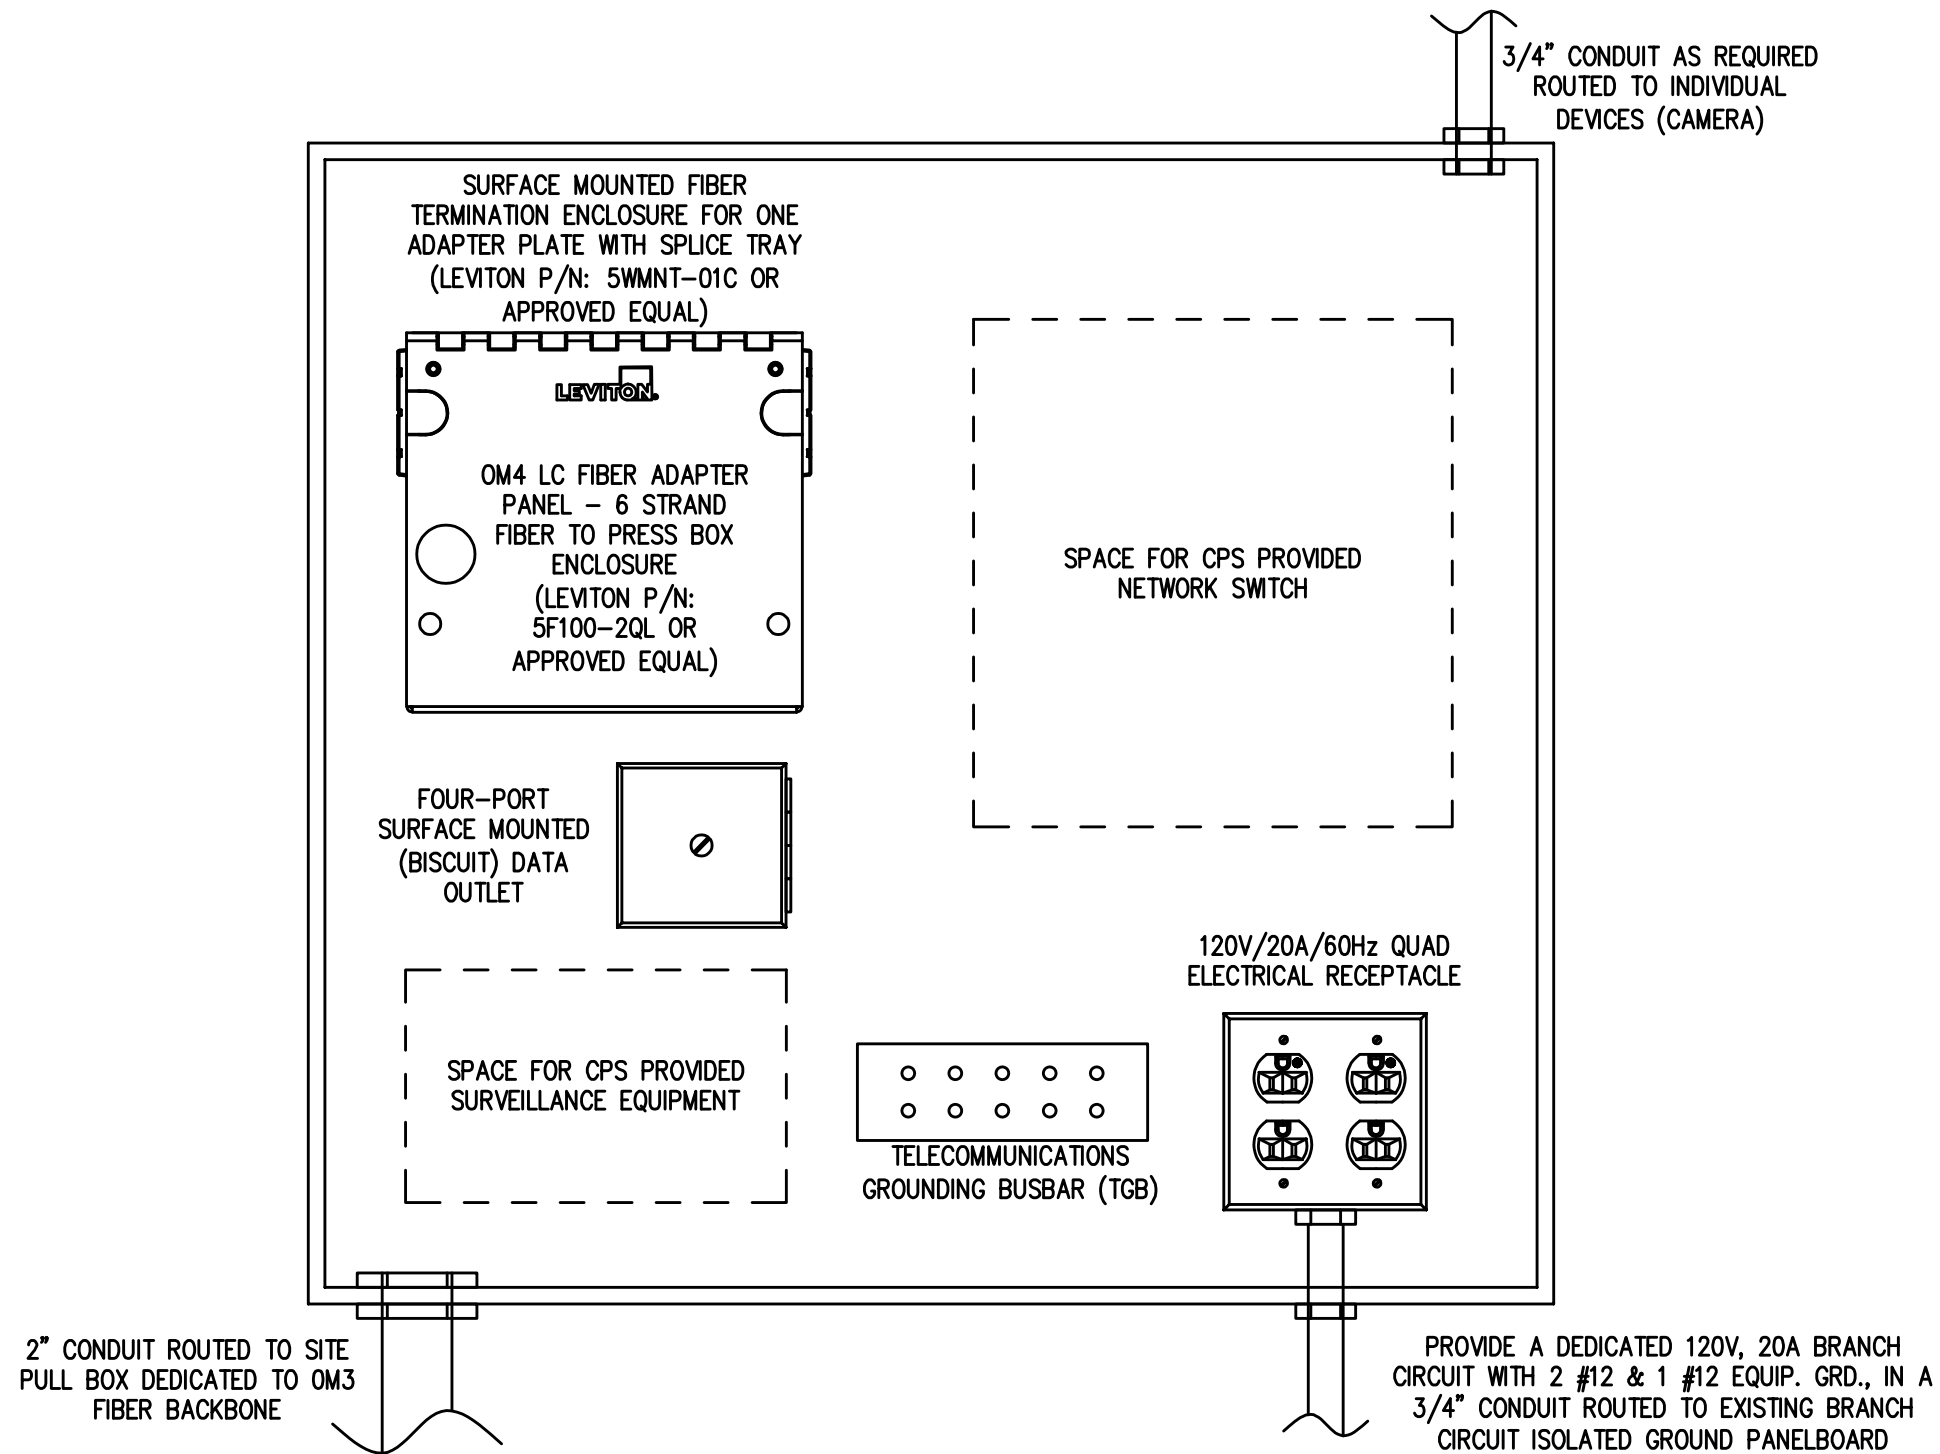

NOTE

1. PROVIDE A 24"W x 24"L x12"D NEMA 4X RATED ENCLOSURE WITH LOCKING DOOR.
2. THE ENCLOSURE'S DOOR SHALL BE MONITORED BY DOOR POSITION SWITCH CONNECTED TO THE EXISTING HONEYWELL VISTA 50P INTRUSION DETECTION SYSTEM.
3. EACH COMPONENT SHALL BE MOUNTED WITH A MINIMUM OF 2" OF SPACE BETWEEN ADJACENT COMPONENTS OR THE ENCLOSURE WALL.
4. REFER TO SITE PLAN AND DETAILS FOR CABLE REQUIREMENTS AND ROUTING.
5. PROVIDE A 6AWG GROUNDING CABLE CONNECTION FROM IT ENCLOSURE TGB BACK TO NEAREST ELECTRICAL GROUNDING SYSTEM.
6. PROVIDE PLUGS TO ENSURE WATER DOES NOT SEEP INTO THE ENCLOSURE.

-	07/06/2026	FY27 DRAWING UPDATES	
NO.	DATE	REVISION	BY

 CHICAGO PUBLIC SCHOOLS CAPITAL IMPROVEMENT PROGRAM OFFICE SAFETY AND SECURITY			
SECURITY STANDARDS			
EXTERIOR IT ENCLOSURE FOR FIBER CONNECTIVITY – EXISTING POLE – MULTIPLE CAMERA CONNECTIONS			
DESIGNED CPS	PROJECT: ITS SYSTEM-DETAILS		SHEET NO. ED.240B
DRAWN CPS			
CHECKED CPS	PROJECT NUMBER	SCALE NTS	
APPROVED CPS		DATE 07/06/2026	