


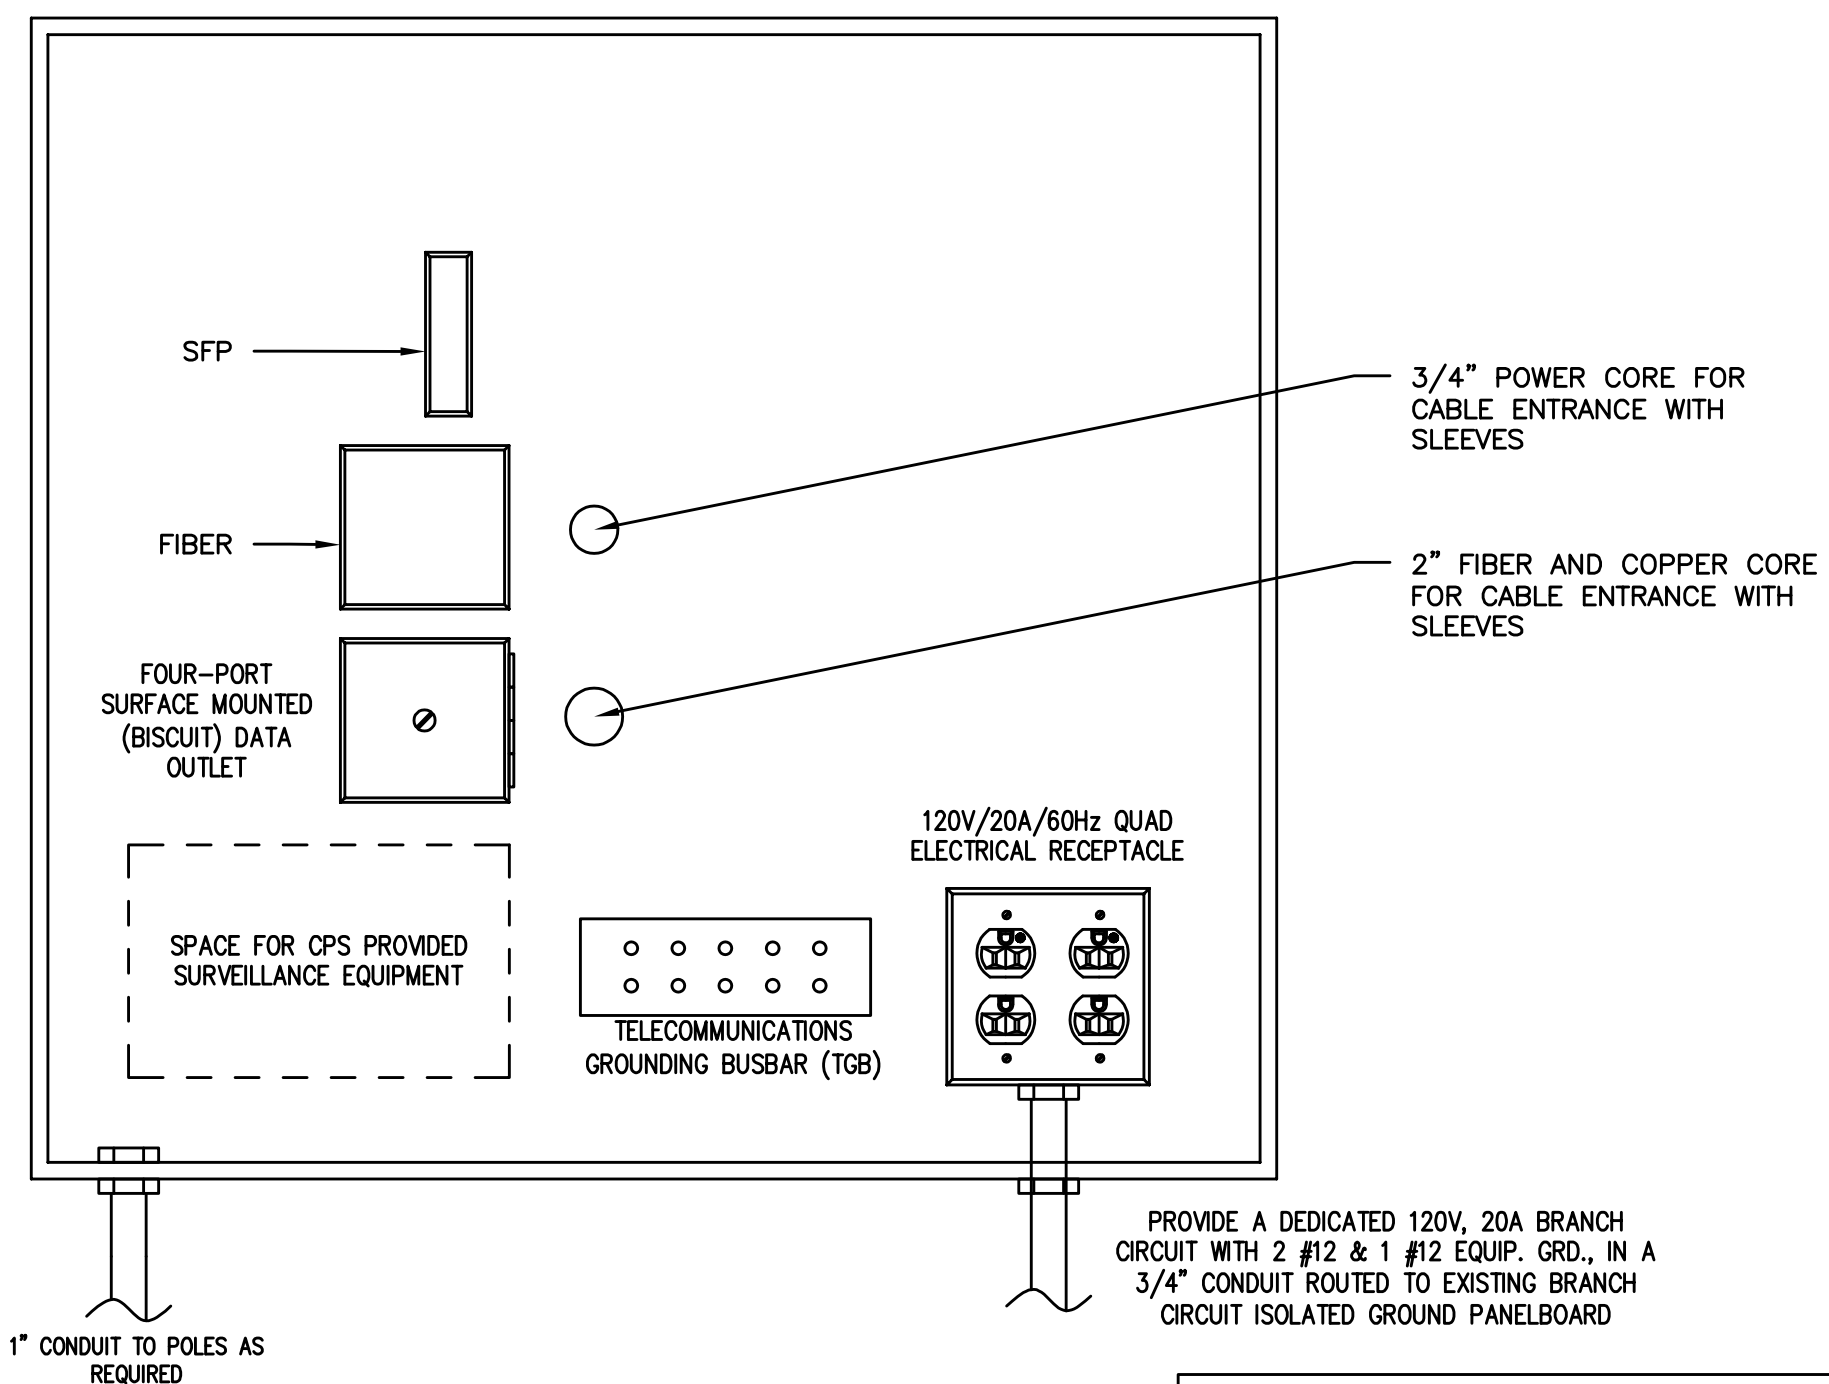

NOTE

1. PROVIDE A 24"W x 24"L x12"D NEMA 4X RATED ENCLOSURE WITH LOCKING DOOR.
2. THE ENCLOSURE'S DOOR SHALL BE MONITORED BY DOOR POSITION SWITCH CONNECTED TO THE EXISTING HONEYWELL VISTA 50P INTRUSION DETECTION SYSTEM.
3. EACH COMPONENT SHALL BE MOUNTED WITH A MINIMUM OF 2" OF SPACE BETWEEN ADJACENT COMPONENTS OR THE ENCLOSURE WALL.
4. REFER TO SITE PLAN AND DETAILS FOR CABLE REQUIREMENTS AND ROUTING.
5. PROVIDE A 6AWG GROUNDING CABLE CONNECTION FROM IT ENCLOSURE TGB BACK TO NEAREST ELECTRICAL GROUNDING SYSTEM.
6. PROVIDE PLUGS TO ENSURE WATER DOES NOT SEEP INTO THE ENCLOSURE.

-	07/06/2026	FY27 DRAWING UPDATES	
NO.	DATE	REVISION	BY



CHICAGO PUBLIC SCHOOLS
CAPITAL IMPROVEMENT PROGRAM
OFFICE SAFETY AND SECURITY

SECURITY STANDARDS

IT ENCLOSURE FOR SINGLE CAMERA
USING FIBER CONNECTIVITY

DESIGNED CPS	PROJECT: ITS SYSTEM-DETAILS			SHEET NO. ED.241
DRAWN CPS				
CHECKED CPS	PROJECT NUMBER	SCALE NTS	DATE 07/06/2026	
APPROVED CPS				